



ALL RIGHTS RESERVED. NO PORTION OF THIS PUBLICATION, WHETHER IN WHOLE OR IN PART CAN BE REPRODUCED WITHOUT THE EXPRESS WRITTEN CONSENT OF SPC TECHNOLOGY.

REVISIONS			DDC. NO. SPC-F004 * Effective: 12/21/98 * DCP No: 680					
DCP #	REV	DESCRIPTION	DRAWN	DATE	CHECKD	DATE	APPRVD	DATE
1979	A	RELEASED	JWM	2/14/00	JN	03/17/08	JN	03/17/08

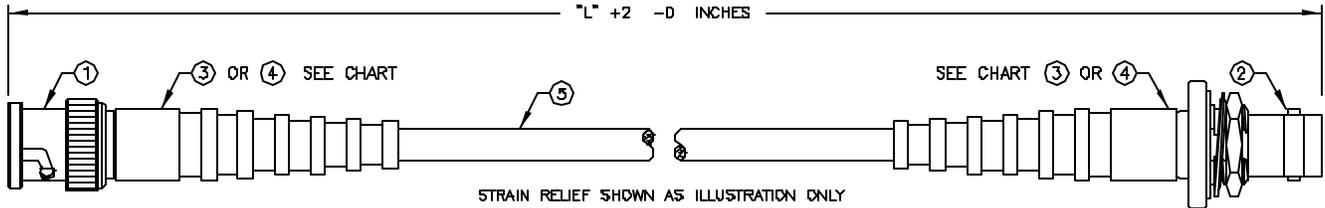

REW-5000-XX  
 [ "L" ] LENGTH IN INCHES  
 SPECIFIC PART NUMBER  
 CABLE ASSEMBLY DESIGNATOR

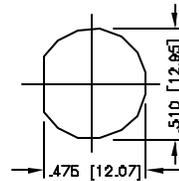

SUGGESTED MOUNTING CONFIGURATION

SPC #	Cable Type	Length	Strain Relief
SPC20672	RG-59B/U	12	No
SPC20673	RG-59B/U	36	No
SPC20772	RG-55B/U	12	No
SPC20773	RG-55B/U	48	No
SPC20774	RG-55B/U	60	No
SPC20775	RG-58A/U	24	Yes
SPC20776	RG-58A/U	36	Yes
SPC20777	RG-58A/U	48	Yes
SPC20778	RG-58A/U	72	Yes
SPC20779	RG-58C/U	24	No
SPC20780	RG-58C/U	48	No
SPC20809	RG-316/U	12	No



SPC-F004.DWG

DISCLAIMER:  
 ALL STATEMENTS AND TECHNICAL INFORMATION CONTAINED HEREIN ARE BASED UPON INFORMATION AND/OR TESTS WE BELIEVE TO BE ACCURATE AND RELIABLE. SINCE CONDITIONS OF USE ARE BEYOND OUR CONTROL, THE USER SHALL DETERMINE THE SUITABILITY OF THE PRODUCT FOR THE INTENDED USE AND ASSUME ALL RISK AND LIABILITY WHATSOEVER IN CONNECTION THEREWITH.



**SPC TECHNOLOGY**

UNLESS OTHERWISE SPECIFIED, DIMENSIONS ARE FOR REFERENCE PURPOSES ONLY.	DRAWN BY:	DATE:	DRAWING TITLE: CABLE ASSEMBLY BNC MALE CRIMP TO BNC FEMALE CRIMP BULKHEAD			
	Jeff McVicker	2/14/00	SIZE	DWG. NO.	ELECTRONIC FILE	REV
	CHECKED BY:	DATE:	A	TA-841	TA-841.DWG	A
	Jason Nash	03/17/08	SCALE: NTS	U.O.M.: INCHES [mm]	SHEET: 1 OF 1	
	APPROVED BY:	DATE:				
	Jason Nash	03/17/08				